


THIS DRAWING IS THE PROPERTY OF THE CONSULTANTS AND SHALL NOT BE COPIED OR USED IN ANY WAY WITHOUT THEIR PERMISSION.

NOTES :
ALL DIMENSIONS SHALL BE CHECKED AND CORRELATED WITH THE RELEVANT ARCHITECTURAL, STRUCTURAL AND OTHER CONSULTANTS DRAWINGS. ANY DISCREPANCY OR OMISSION SHALL BE BROUGHT TO THE NOTICE OF THE CONSULTANTS IMMEDIATELY BEFORE COMMENCING THE WORK.

Good for Construction

LEGEND			
	SYMBOL	DESCRIPTION	MOUNTING HEIGHT
		1200MM Ø CEILING FAN WITH PROPOSED	ON CEILING
		1X40W LED SURFACE MOUNTED LIGHT FIXTURE	ON CEILING
		EXISTING LIGHT POINT	ON CEILING
		18W SURFACE MOUNTED ROUND TYPE DOWNLIGHTER LIGHT FIXTURE (Edge surface-round- XT-LDRER-18-W-V2-XT)	ON CEILING
		18W SURFACE MOUNTED ROUND TYPE DOWNLIGHTER LIGHT FIXTURE (Edge surface-round- XT-LDRER-12-W-V2-XT)	ON CEILING
		10 WALL MOUNTED PICTURE LIGHT FIXTURE	2100MM FROM FFL
		LOCATION OF ONE WAY SWITCH BOARD	1200MM FROM FFL
		LOCATION OF TWO WAY SWITCH BOARD	1200MM FROM FFL
		450 MM DIA EXHAUST FAN	IN WALL/VENTILATOR
		300 MM DIA EXHAUST FAN	IN WALL
		10W MIRROR LIGHT FIXTURE Taskline SQ AL-LBLN-20W-SQ-AL	IN WALL
		5 W UP & DOWN LIGHT	1800 FROM FFL
		32A DP MCB FOR AC UNIT	2400 FROM FFL
		16A 6PIN SOCKET 450 MM ABOVE WORKING COUNTER	

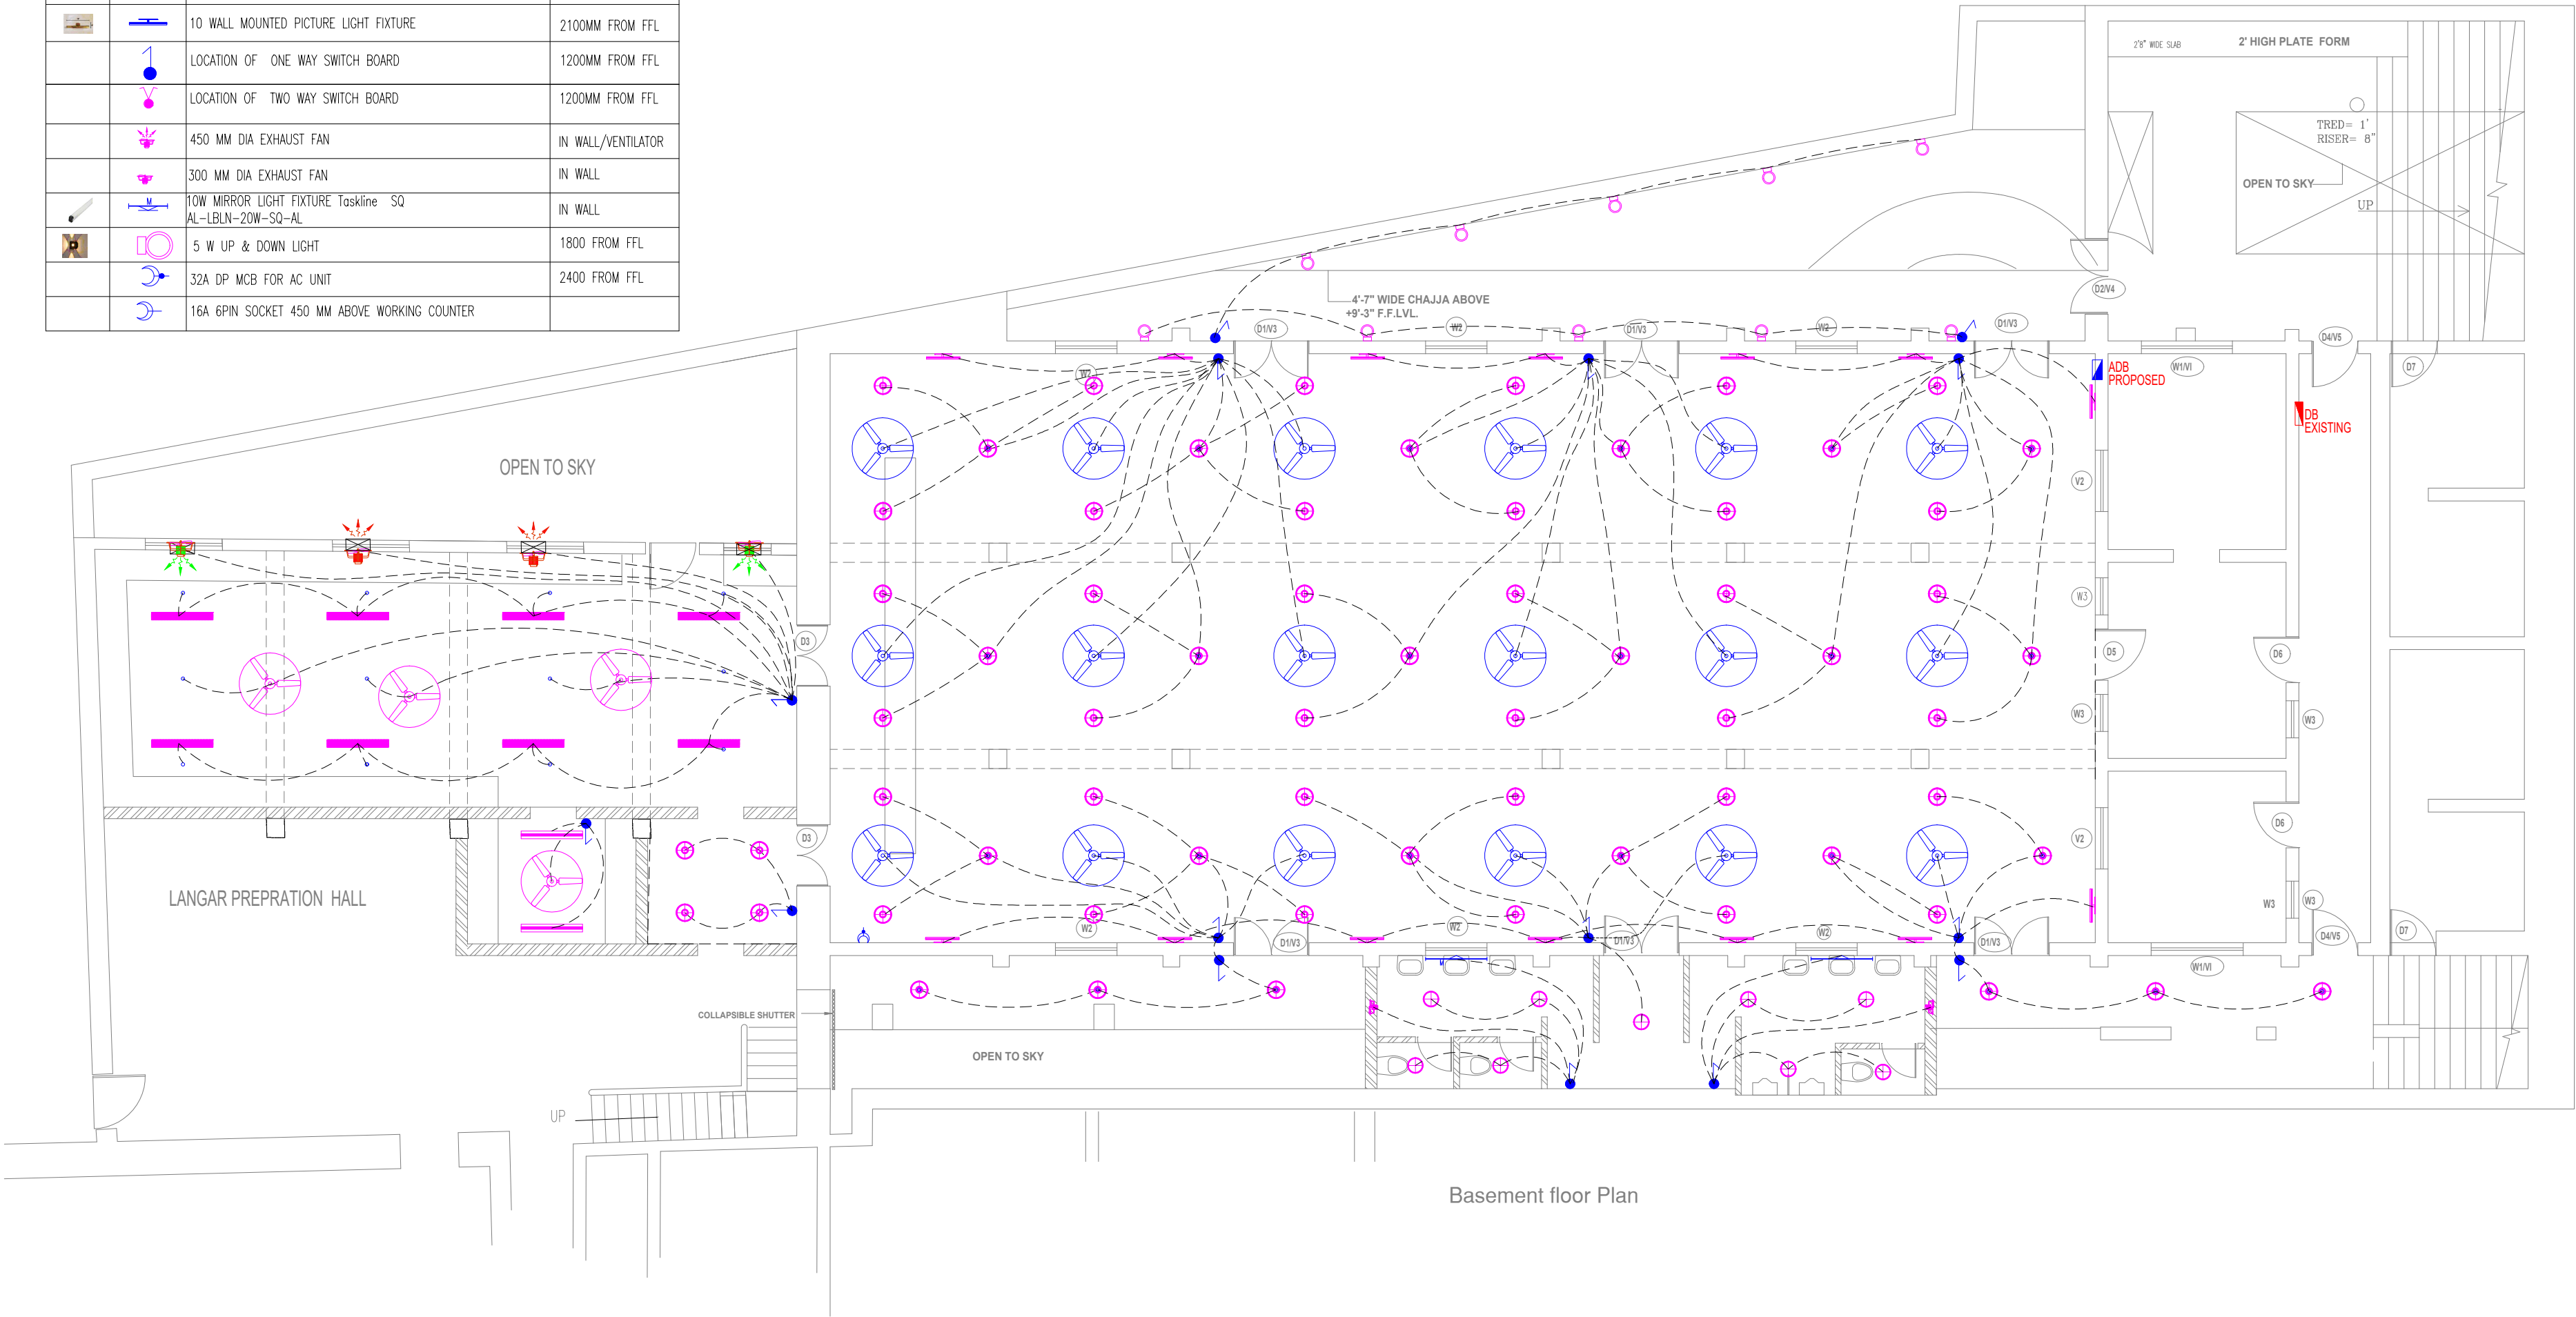

Basement floor Plan

DATE	NO.	REVISIONS	BY	DATE	NO.	ISSUED TO	BY

Owner:
Existing Building Plan for
Shri Adya Katayani Shaktipeeth Trust
at Chattarpur, New Delhi.

JOB TITLE:
Maa Mahishasur Mardani Mandir

DRAWING TITLE			
Basement floor Plan ELECTRICAL LAYOUT			
Temple			
DATE:	19.08.2026	DESIGN:	R.C
SCALE:	1"=4'-0"	APPD BY:	

ARCHITECT:



PC DESIGNS
PRIVATE LIMITED
ARCHITECTS* ENGINEERS* PLANNERS
340,SULTANPUR, MG ROAD,
NEW DELHI-110030

JOB NO.	CATEGORY	DRG. NO.	STATUS
PROJ#	WD	EL-201	R-0