
 


LEGEND	
SYMBOL	DESCRIPTION
	2.0 TR 750 CFM DX TYPE HI WALL UNIT
	DX OUTDOOR UNIT, 2.0 TR
	450ø PROPELLER FAN 2500 CFM EACH FOR FRESH AIR LOUVER WITH BIRD SCREEN,
	450ø PROPELLER FAN 2500 CFM EACH FOR EXHAUST AIR LOVER WITH BIRD SCREEN,
	300 MM DIA EXHAUST FAN
	32A DP MCB FOR AC UNIT
	16A 6PIN SOCKET 450 MM ABOVE WORKING COUNTER

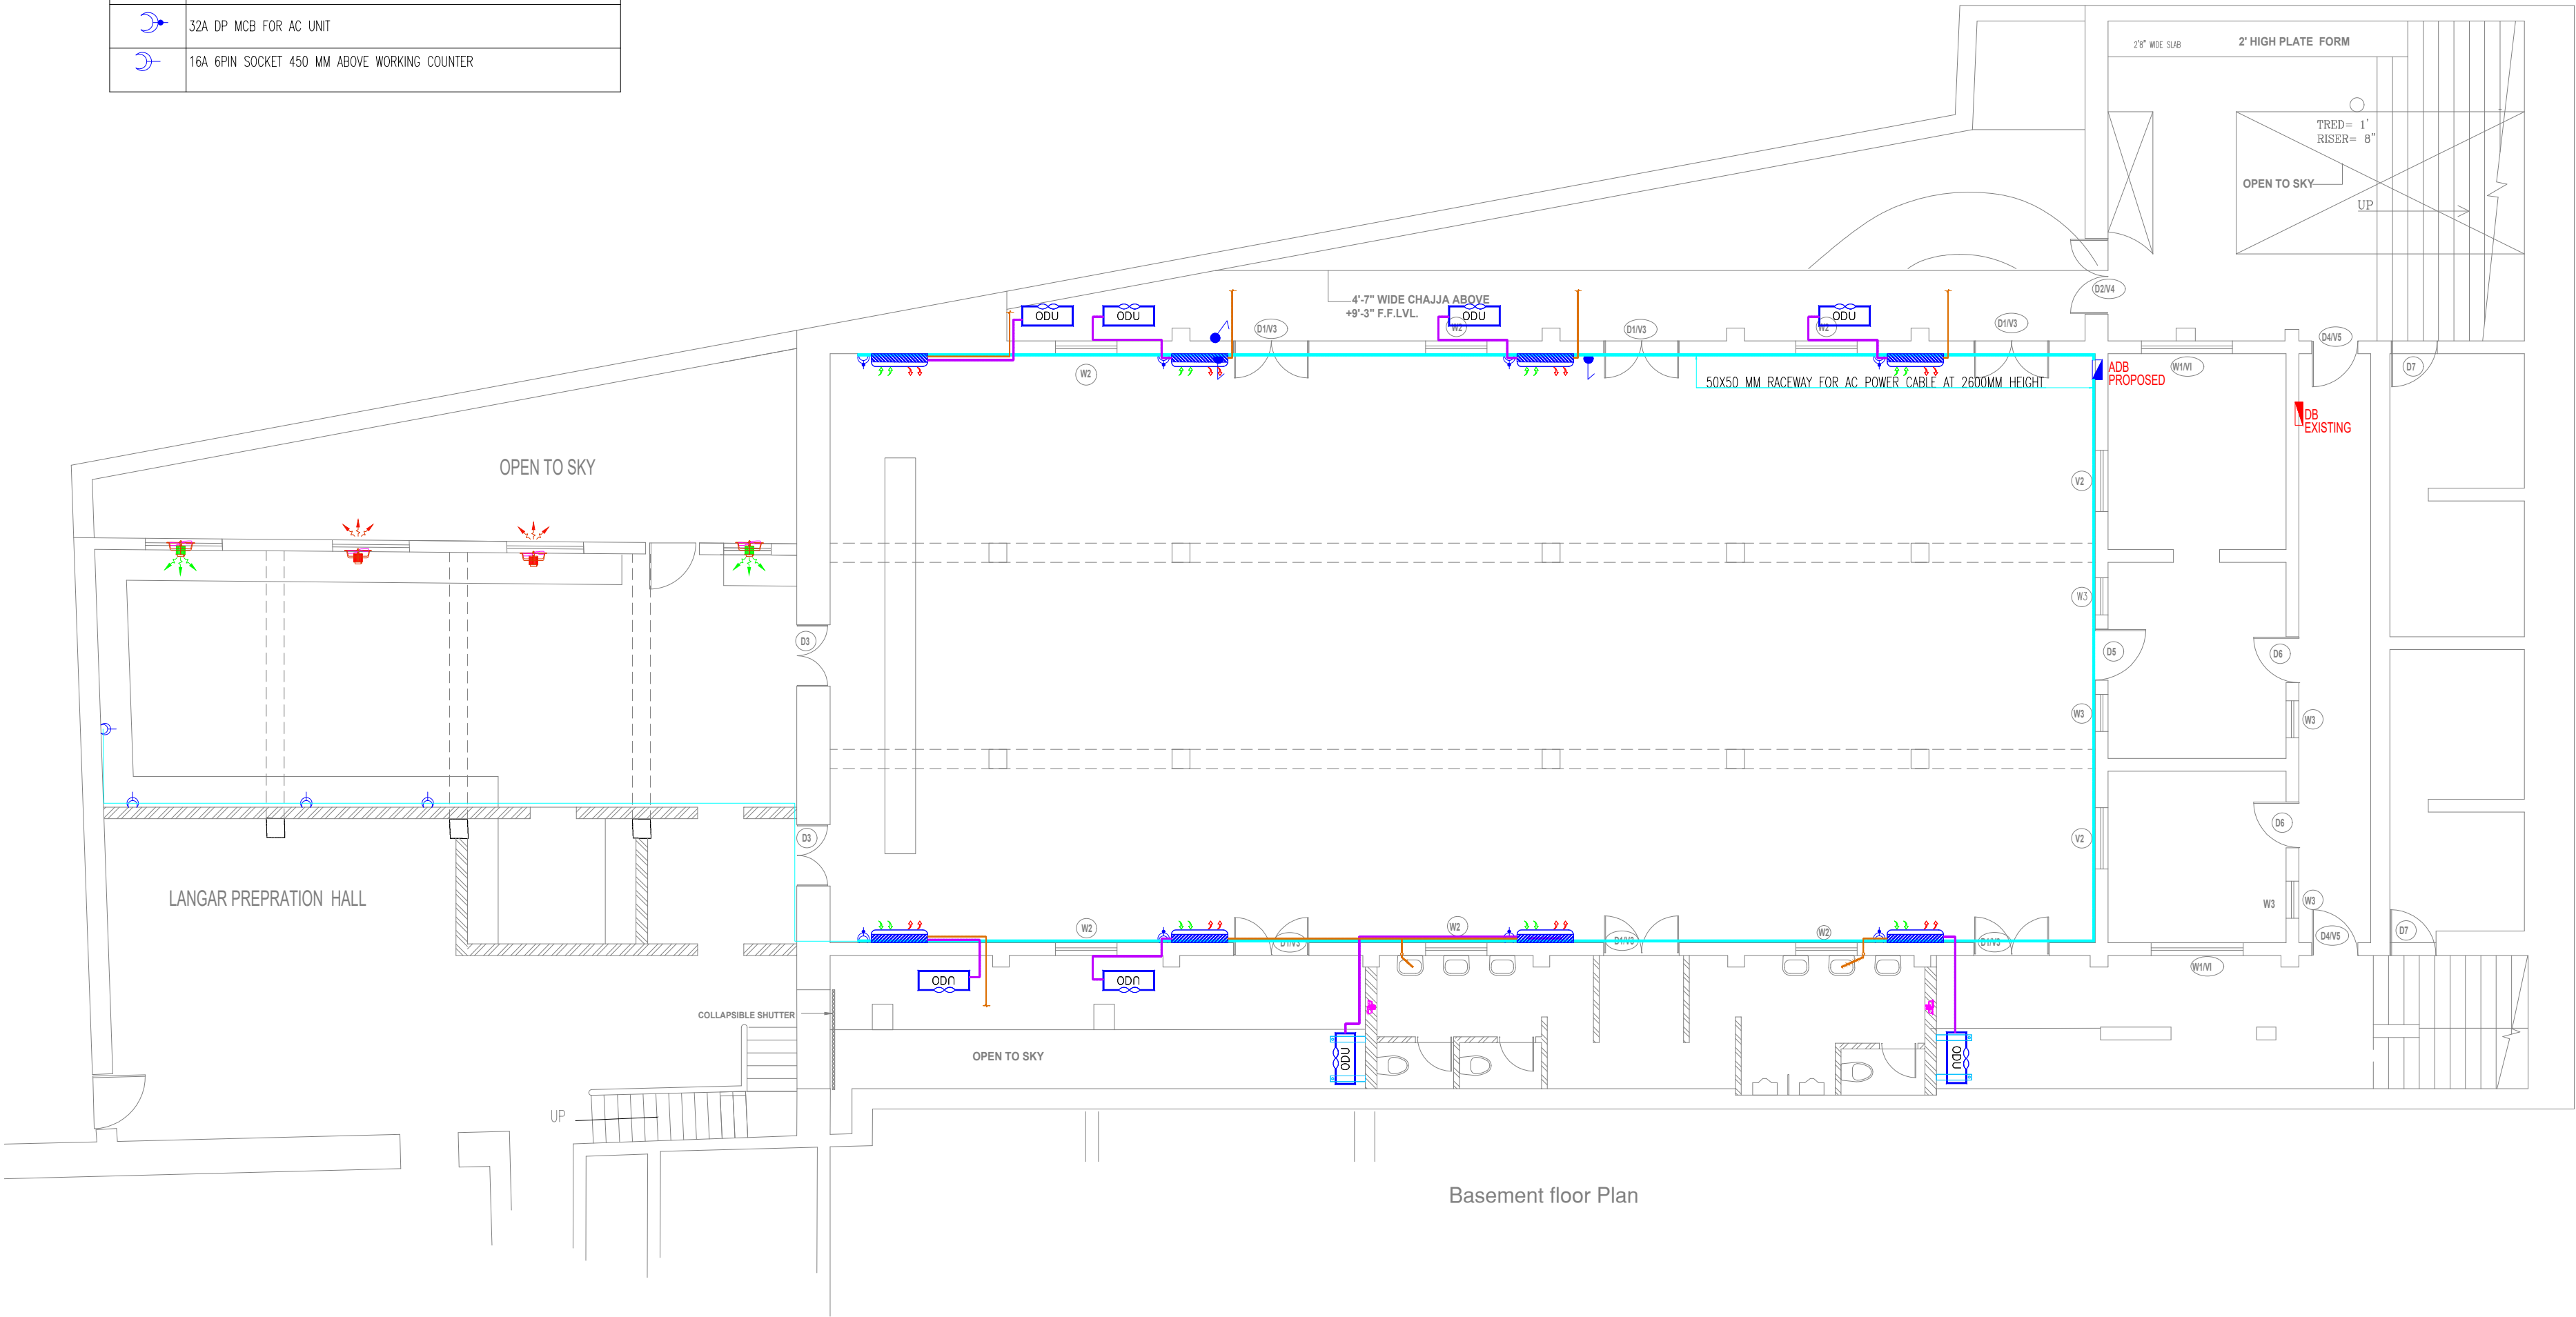

Basement floor Plan



THIS DRAWING IS THE PROPERTY OF THE CONSULTANTS AND SHALL NOT BE COPIED OR USED IN ANY WAY WITHOUT THEIR PERMISSION.

NOTES :
ALL DIMENSIONS SHALL BE CHECKED AND CORRELATED WITH THE RELEVANT ARCHITECTURAL, STRUCTURAL AND OTHER CONSULTANTS DRAWINGS. ANY DISCREPANCY OR OMISSION SHALL BE BROUGHT TO THE NOTICE OF THE CONSULTANTS IMMEDIATELY BEFORE COMMENCING THE WORK.

Good for Construction

DATE	NO.	REVISIONS	APPD.
DATE	NO.	ISSUED TO	BY

Owner:
Existing Building Plan for
Shri Adya Katayani Shaktipeeth Trust
at Chattarpur, New Delhi.

JOB TITLE:
Maa Mahishasur Mardani Mandir

DRAWING TITLE			
Basement floor Plan AC POWER LAYOUT			
Temple			
DATE:	19.08.2026	DESIGN:	R.C
SCALE:	1"=4'-0"	APPD BY:	

ARCHITECT:



PC DESIGNS
PRIVATE LIMITED
ARCHITECTS* ENGINEERS* PLANNERS
340,SULTANPUR, MG ROAD,
NEW DELHI-110030

JOB NO.	CATEGORY	DRG. NO.	STATUS
PROJ#	WD	EL-201	R-0